

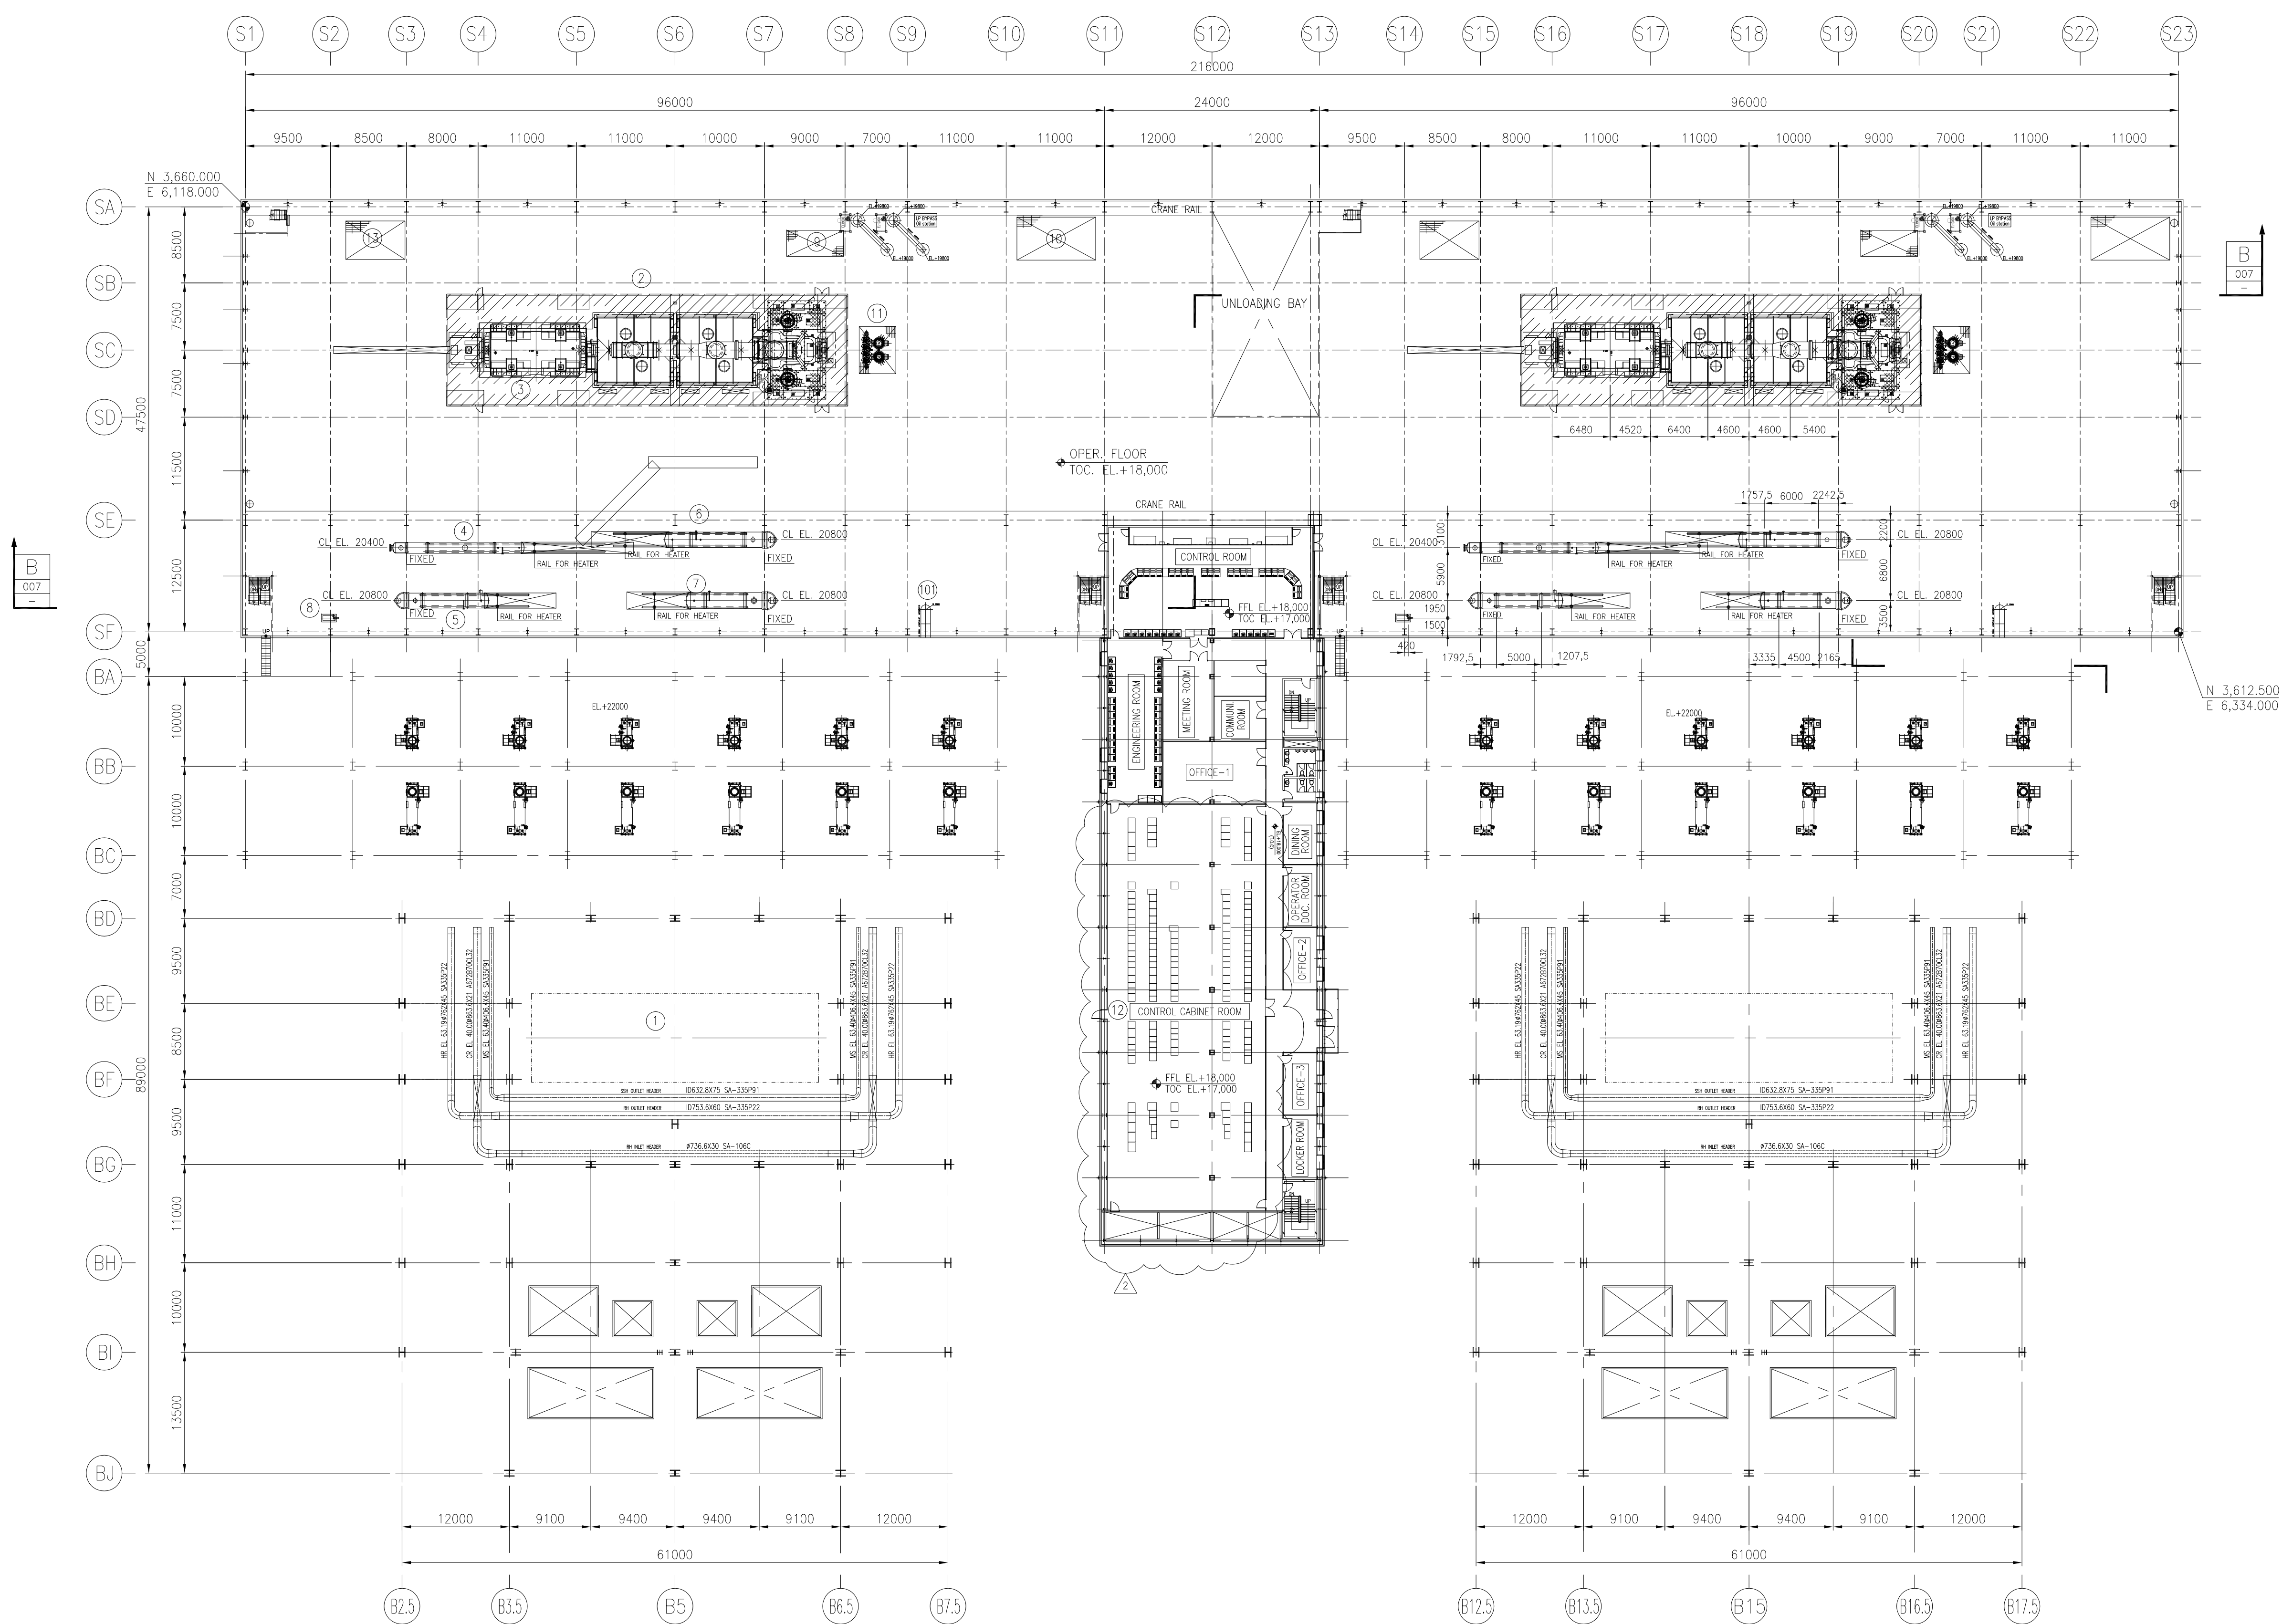


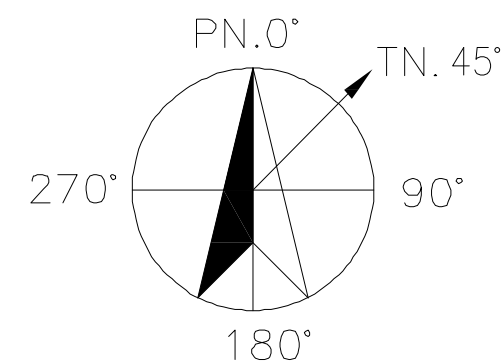

 
 
OPERATING FLOOR
TOC. EL. +18,000

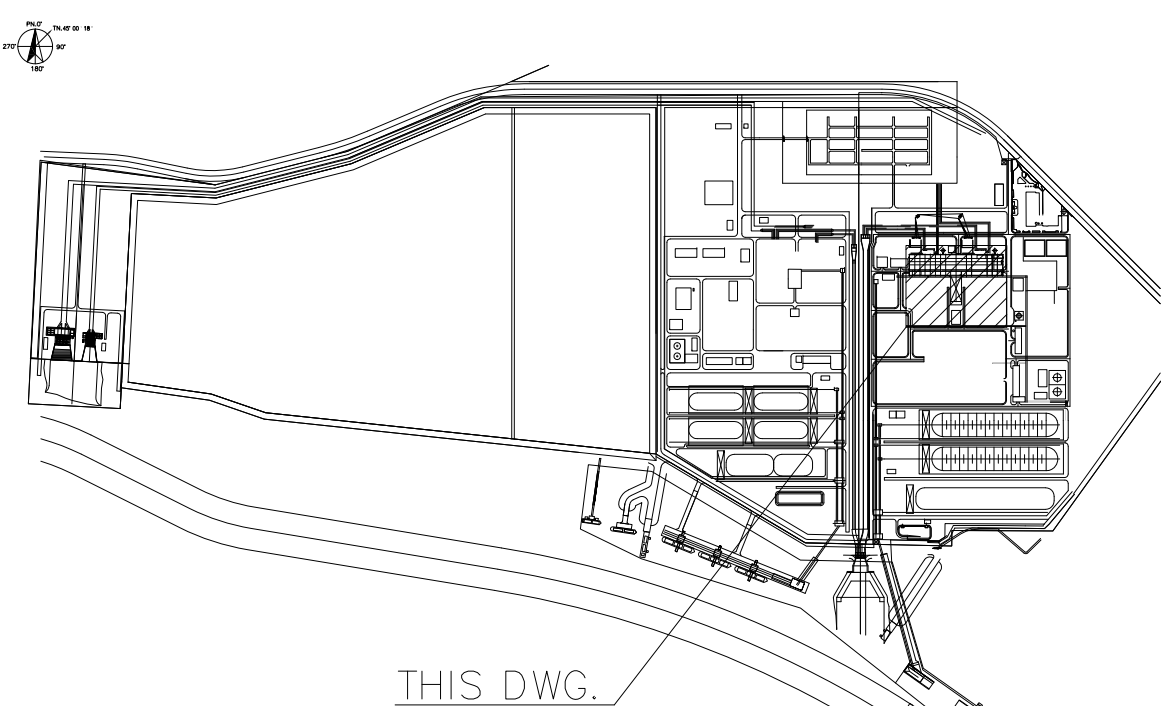

KEY PLAN

LEGEND			
ITEM NO.	DESCRIPTION	EQUIPMENT NO.	REMARK
1	PULVERIZED COAL FIRED BOILER	11HAN-AC010	
2	STEAM TURBINE	11MAA10-HB210	
3	GENERATOR	11MAK01-HB210	
4	LP FEEDWATER HEATER #4	11LCC10-AC004	
5	HP FEEDWATER HEATER #6	11LAD10-AC006	
6	HP FEEDWATER HEATER #7	11LAD10-AC007	
7	HP FEEDWATER HEATER #8	11LAD10-AC008	
8	DEAERATOR RECIRCULATION PUMP	11LAC10-AP006	
9	CONDENSATE PUMPS REMOVAL HATCH	-	
10	TURBINE LUBE OIL TANK ACCESS HATCH	-	
11	MSV/OV REMOVAL HATCH	-	
12	MAIN CONTROL BUILDING	-	
13	COB REMOVAL HATCH	-	
101	COLD REHEAT LINES	12LBC11-BR001	

- NOTE**
- DIMENSIONS ARE IN MILLIMETERS UNLESS OTHERWISE STATED.
 - FINISHED GRADE ELEVATION EL.±0.00m = GL.±0.00m = MSL EL. +4.5m
 - REFERENCE DWG. NO.:
STB & AUX : TB2-SDC-VP10101-00100-M-M18-DAL-0001
CONDENSER : TB2-SDC-VP101-00100-M-M18-DGA-0001
BOILER : TB2-SDC-VP101-00100-M-M18-DGA-0001
ESP : TB2-SDC-VP101-00100-M-M18-DGA-0004
FGD : TB2-SDC-VP101-00100-M-M18-DGA-0001
 - ANY CHANGES, REVISIONS, AND/OR AMENDMENTS OF THIS DRAWING SHALL BE CONDUCTED WITH PRIOR WRITTEN CONFIRMATION FROM THE FIELD ENGINEER.

△	02.JUL.2015	REVISED AS PER MARKED	W.S.CHIO	J.S.JANG	J.H.PARK	Y.H.KIM
△	31.OCT.2014	REVISED AS PER MARKED	H.T.ANN	J.S.JANG	J.H.PARK	Y.H.KIM
△	30.APR.2014	REVISED AS PER MARKED	H.T.ANN	J.S.JANG	J.H.PARK	Y.H.KIM
△	03.DEC.2013	FOR CONSTRUCTION	H.T.ANN	J.H.PARK	J.H.PARK	Y.H.KIM
REV	DATE	DESCRIPTION	PREP	CHKD	APRD	
OWNER		OWNER'S CONSULTANT				
		FICHTNER GmbH & Co. KG				
VIETNAM OIL AND GAS GROUP (PVN)		FICHTNER		PY POWER PCC		
EPC CONTRACTOR		EPC CONTRACTOR'S CONSULTANT				
				WorleyParsons		
PETERWETNAM CONSTRUCTION JOINT STOCK CORPORATION (PCC)		WORLEYPARSONS				
POWER ISLAND PACKAGE SUPPLIER		DAELIM				
		DAELIM INDUSTRIAL CO., LTD.				
SOJITZ CORPORATION						
PROJECT TITLE						
THAI BINH2 THERMAL POWER PLANT 2 x 600MW						
DRAWING TITLE						
EQUIPMENT ARRANGEMENT PLAN FOR STEAM TURBINE AREA OPERATING FLOOR EL.+18,000						
DAELIM		FUNCTION	NAME	SIGN	DATE	
		DRWN	W.S.CHIO		02.JUL.2015	
		CHKD	J.S.JANG		02.JUL.2015	
		APPD	J.H.PARK		02.JUL.2015	
		APPD	Y.H.KIM		02.JUL.2015	
DRAWING NO.		JOB NO.	SCALE	REVNO		
TB2-SDC-00100-P-MB-DGA-0003			1/400			
1.1		FILE NAME TB2-SDC-00100-P-MB-DGA-0003				