


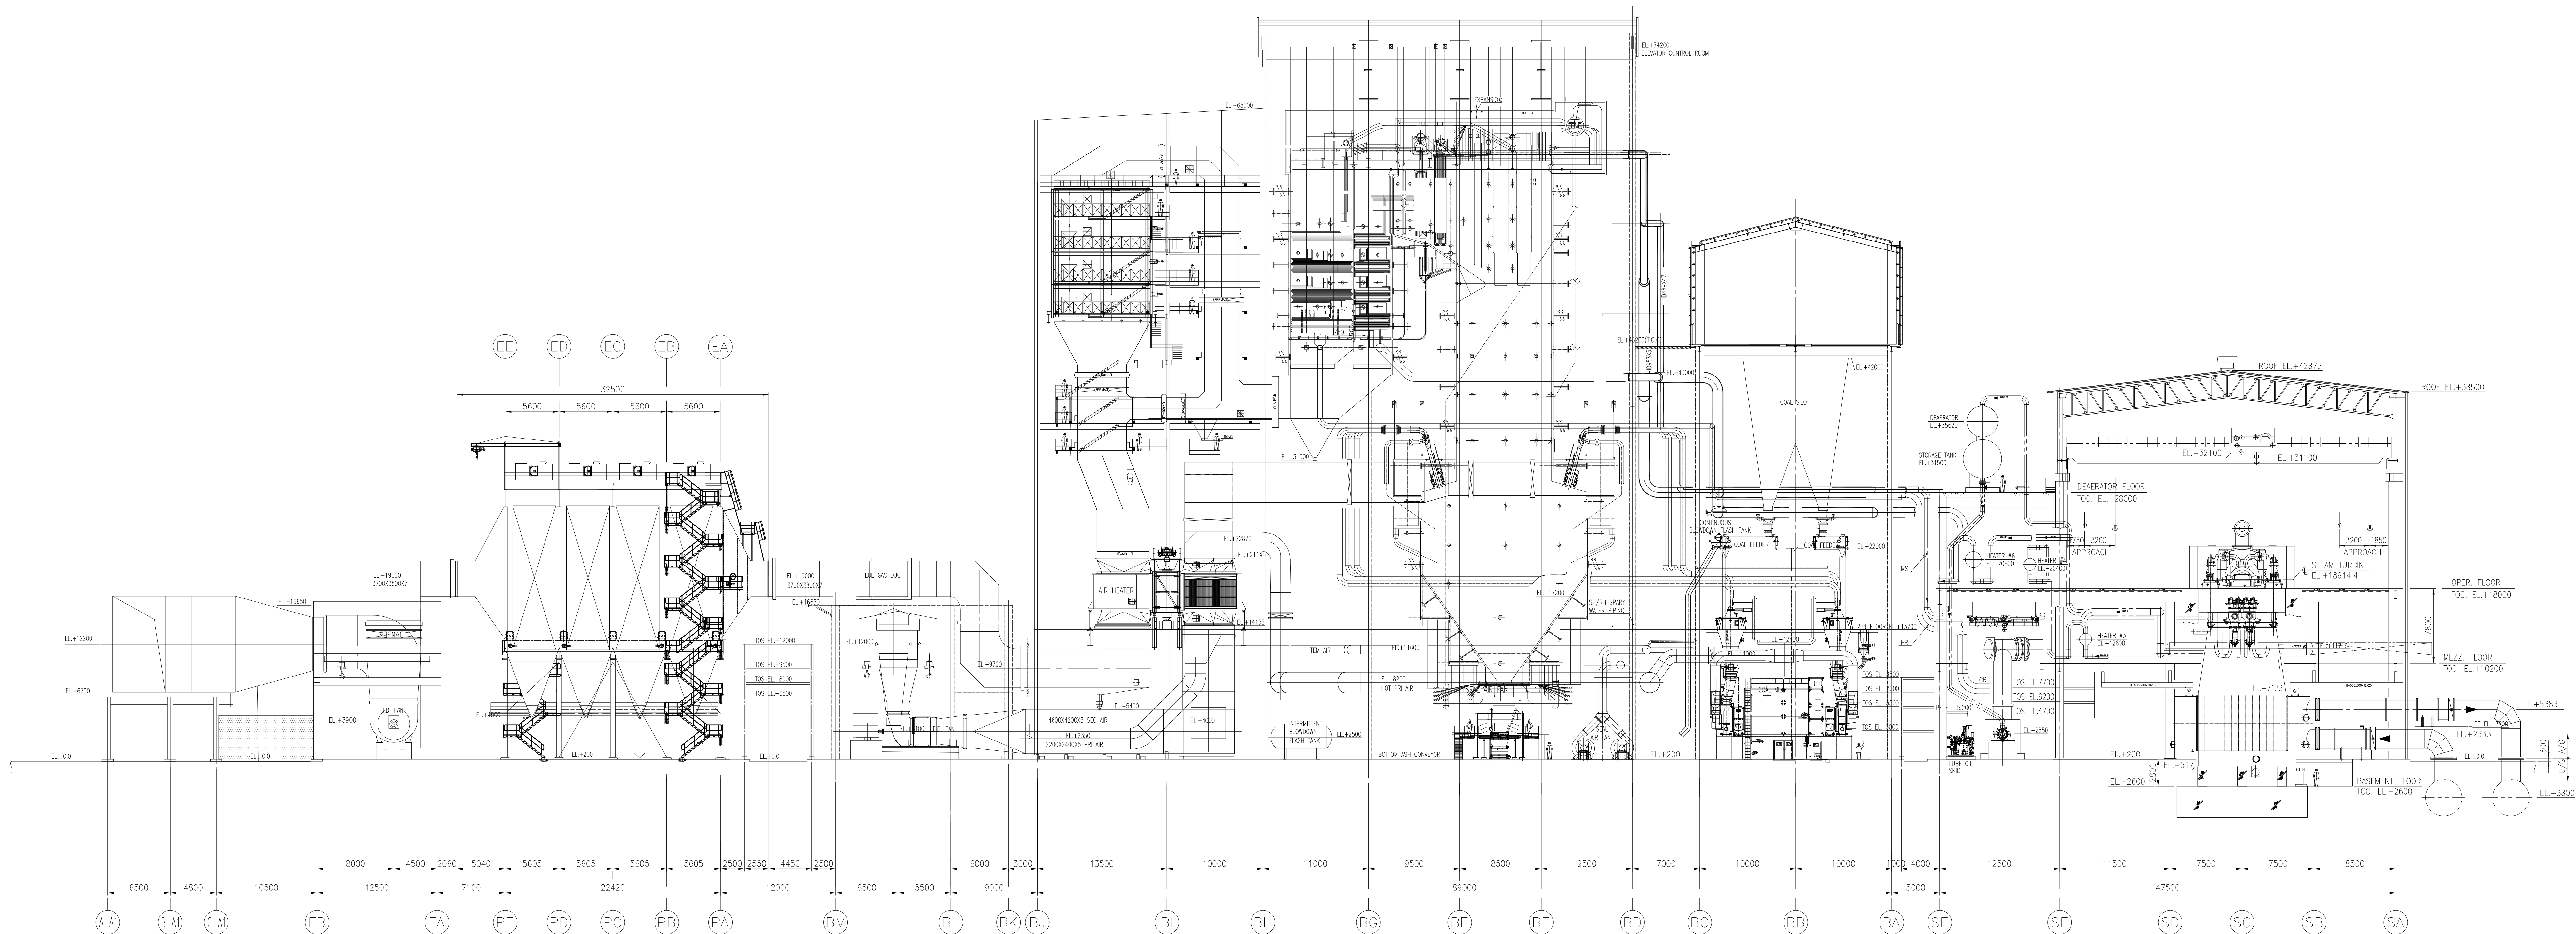

SECTION "A-A"

NOTE

1. DIMENSIONS ARE IN MILLIMETERS UNLESS OTHERWISE STATED.
2. FINISHED GRADE ELEVATION EL+0.00m = GL+0.00m = MSL EL +4.5m
3. REFERENCE DWG. NO.:
 - STG & AUX : TB2-SDC.VPM210171-00100-M-M1B-DAL-0001
 - CONDENSER : TB2-SDC.VP107-00KAC-M-M1B-DGA-0001
 - BOILER : TB2-SDC.VP101-01100-M-M1A-DGA-0001
 - ESP : TB2-SDC.VP101-01100-M-M1A-DGA-5004
 - FGD : TB2-SDC.VP101-00100-M-M10-DGA-0001
4. ANY CHANGES, REVISIONS, AND/OR AMENDMENTS OF THIS DRAWING SHALL BE CONDUCTED WITH PRIOR WRITTEN CONSENT FROM THE FIELD ENGINEER.

DOCUMENT SUBMISSION STATUS APAC					
NOTE:					
	02.04.2015	FOR CONSTRUCTION	#5.CHO	L.S.JANG	J.H.PARK
	31.03.2014	REVISED AS PER MARKED	H.TAPPI	L.S.JANG	J.H.PARK
	29.AUG.2014	FOR CONSTRUCTION	H.TAPPI	L.S.JANG	J.H.PARK
REV	DATE	DESCRIPTION	PREP	CHKD	APRD
OWNER		OWNER'S CONSULTANT			
 VIETNAM OIL AND GAS GROUP (VNG)		 FICHTNER Gerth & Co. JG FICHTNER		 ASIAN POWER PCC	
EPC CONTRACTOR		EPC CONTRACTOR'S CONSULTANT			
 Pervietnam Construction Joint Stock Corporation (PVC)		 WORLEYPARSONS WORLDWIDE			
POWER ISLAND PACKAGE SUPPLIER		DAELIM INDUSTRIAL CO., LTD.			
 SOJITZ CORPORATION		 DAELIM INDUSTRIAL CO., LTD.			
PROJECT TITLE					
THAI BINH2 THERMAL POWER PLANT 2 x 600MW					
DRAWING TITLE					
EQUIPMENT ARRANGEMENT FOR POWER BLOCK AREA SECTION (1/2)					
 DRAWING NO: TB2-SDC-00100-P-MB-DGA-0006		FUNCTION	NAME	SIGN	DATE
		DRAIN	W.S.CHO		02.JUL.2015
		CHKD	L.S.JANG		02.JUL.2015
		APPD	J.H.PARK		02.JUL.2015
		REV	Y.H.KIM		02.JUL.2015
JOB NO.		SCALE		REVISION	
TB2-SDC-00100-P-MB-DGA-0006		1/250		RECD	