


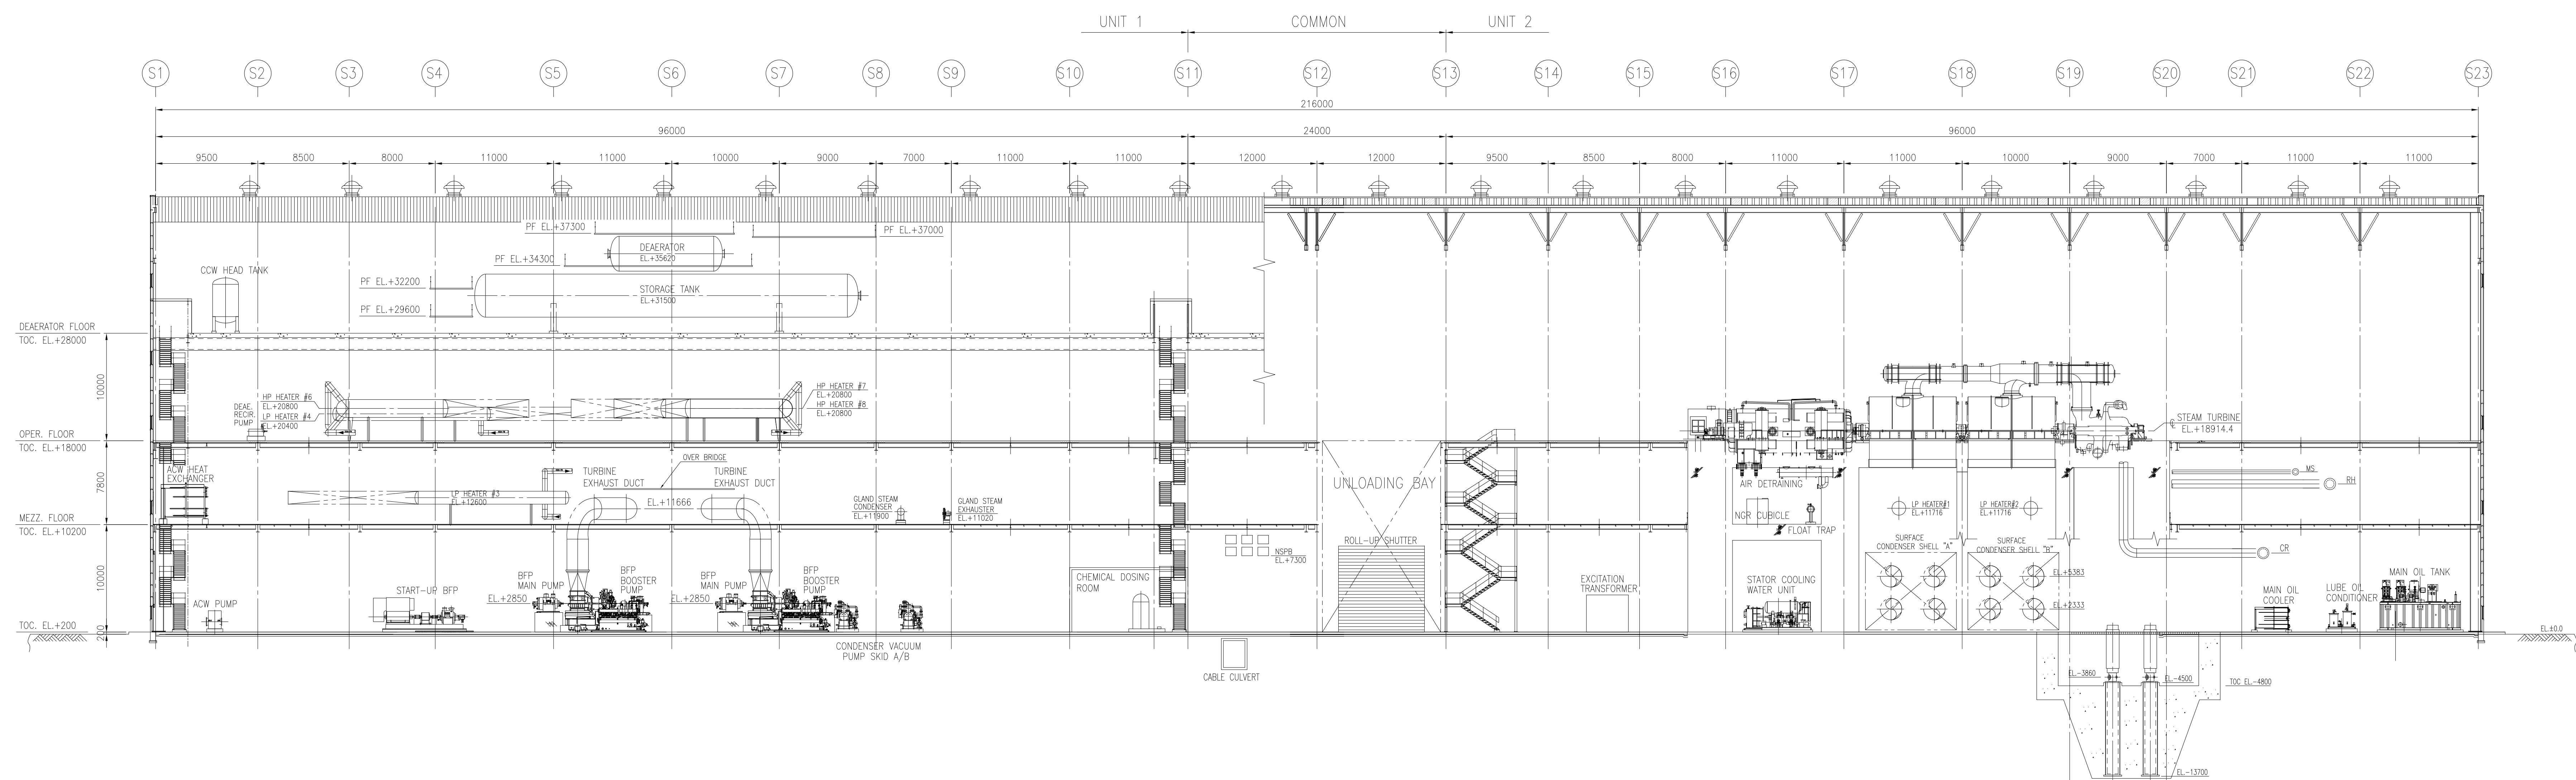

SECTION "B-B"

NOTE

1. DIMENSIONS ARE IN MILLIMETERS UNLESS OTHERWISE STATED.
2. FINISHED GRADE ELEVATION EL+0.00m = GL+0.00m = MSL EL +4.5m
3. REFERENCE DWG. NO.:
 - STG & AUX.: TB2-SDC.VPM210171-00100-M-M1B-DAL-0001
 - CONDENSER.: TB2-SDC.VP107-00KAC-M-M1B-DGA-0001
 - BOILER.: TB2-SDC.VP101-00KAC-M-M1A-DGA-0001
 - ESP.: TB2-SDC.VP101-01100-M-M1A-DGA-5004
 - FGD.: TB2-SDC.VP101-00100-M-M10-DGA-0001
4. ANY CHANGES, REVISIONS, AND/OR AMENDMENTS OF THIS DRAWING SHALL BE CONDUCTED WITH PRIOR WRITTEN CONSENT FROM THE FIELD ENGINEER.

DOCUMENT SUBMISSION STATUS: AP

NOTE:

△	02.AIL.2015	FOR CONSTRUCTION	W.S.CHO	I.S.JANG	J.H.PARK	Y.H.KIM																				
	31.OCT.2014	REVISED AS PER MARKED	H.TAHN	I.S.JANG	J.H.PARK	Y.H.KIM																				
	30.APR.2014	REVISED AS PER MARKED	H.TAHN	I.S.JANG	J.H.PARK	Y.H.KIM																				
	03.DEC.2013	FOR CONSTRUCTION	H.TAHN	C.A.CHOI	J.H.PARK	Y.H.KIM																				
REV	DATE	DESCRIPTION	PREP	CHKD	APRD	APRD																				
OWNER			OWNER'S CONSULTANT																							
			FICTIONER GmbH & Co. KG FICTIONER																							
VIETNAM OIL AND GAS GROUP (VNG)			FICTIONER		PW POWER PCC																					
EPC CONTRACTOR			EPC CONTRACTOR'S CONSULTANT																							
			 WorleyParsons a subsidiary of WORLEYPARSONS																							
PETROVIETNAM CONSTRUCTION JOINT STOCK CORPORATION (PVC)			WORLEYPARSONS																							
POWER ISLAND PACKAGE SUPPLIER			DAELIM INDUSTRIAL CO., LTD.																							
			DAELIM DAELIM INDUSTRIAL CO., LTD.																							
PROJECT TITLE			THAI BINH2 THERMAL POWER PLANT 2 x 600MW																							
DRAWING TITLE			EQUIPMENT ARRANGEMENT FOR POWER BLOCK AREA SECTION (2/2)																							
			<table><tr><th>FUNCTION</th><th>NAME</th><th>SIGN</th><th>DATE</th></tr><tr><td>DRWN</td><td>W.S.CHO</td><td></td><td>02.JULY.2015</td></tr><tr><td>CHKD</td><td>I.S.JANG</td><td></td><td>02.JULY.2015</td></tr><tr><td>APPR</td><td>J.H.PARK</td><td></td><td>02.JULY.2015</td></tr><tr><td>APPR</td><td>Y.H.KIM</td><td></td><td>02.JULY.2015</td></tr></table>		FUNCTION	NAME	SIGN	DATE	DRWN	W.S.CHO		02.JULY.2015	CHKD	I.S.JANG		02.JULY.2015	APPR	J.H.PARK		02.JULY.2015	APPR	Y.H.KIM		02.JULY.2015	REVISION 1/50	
FUNCTION	NAME	SIGN	DATE																							
DRWN	W.S.CHO		02.JULY.2015																							
CHKD	I.S.JANG		02.JULY.2015																							
APPR	J.H.PARK		02.JULY.2015																							
APPR	Y.H.KIM		02.JULY.2015																							
DRAWING NO.			TBD-2-SO-00100-P-WB-DOA-007																							
TBD-2-SO-00100-P-WB-DOA-007			FILE NAME TBD-SO-00100-P-WB-DOA-0001																							