


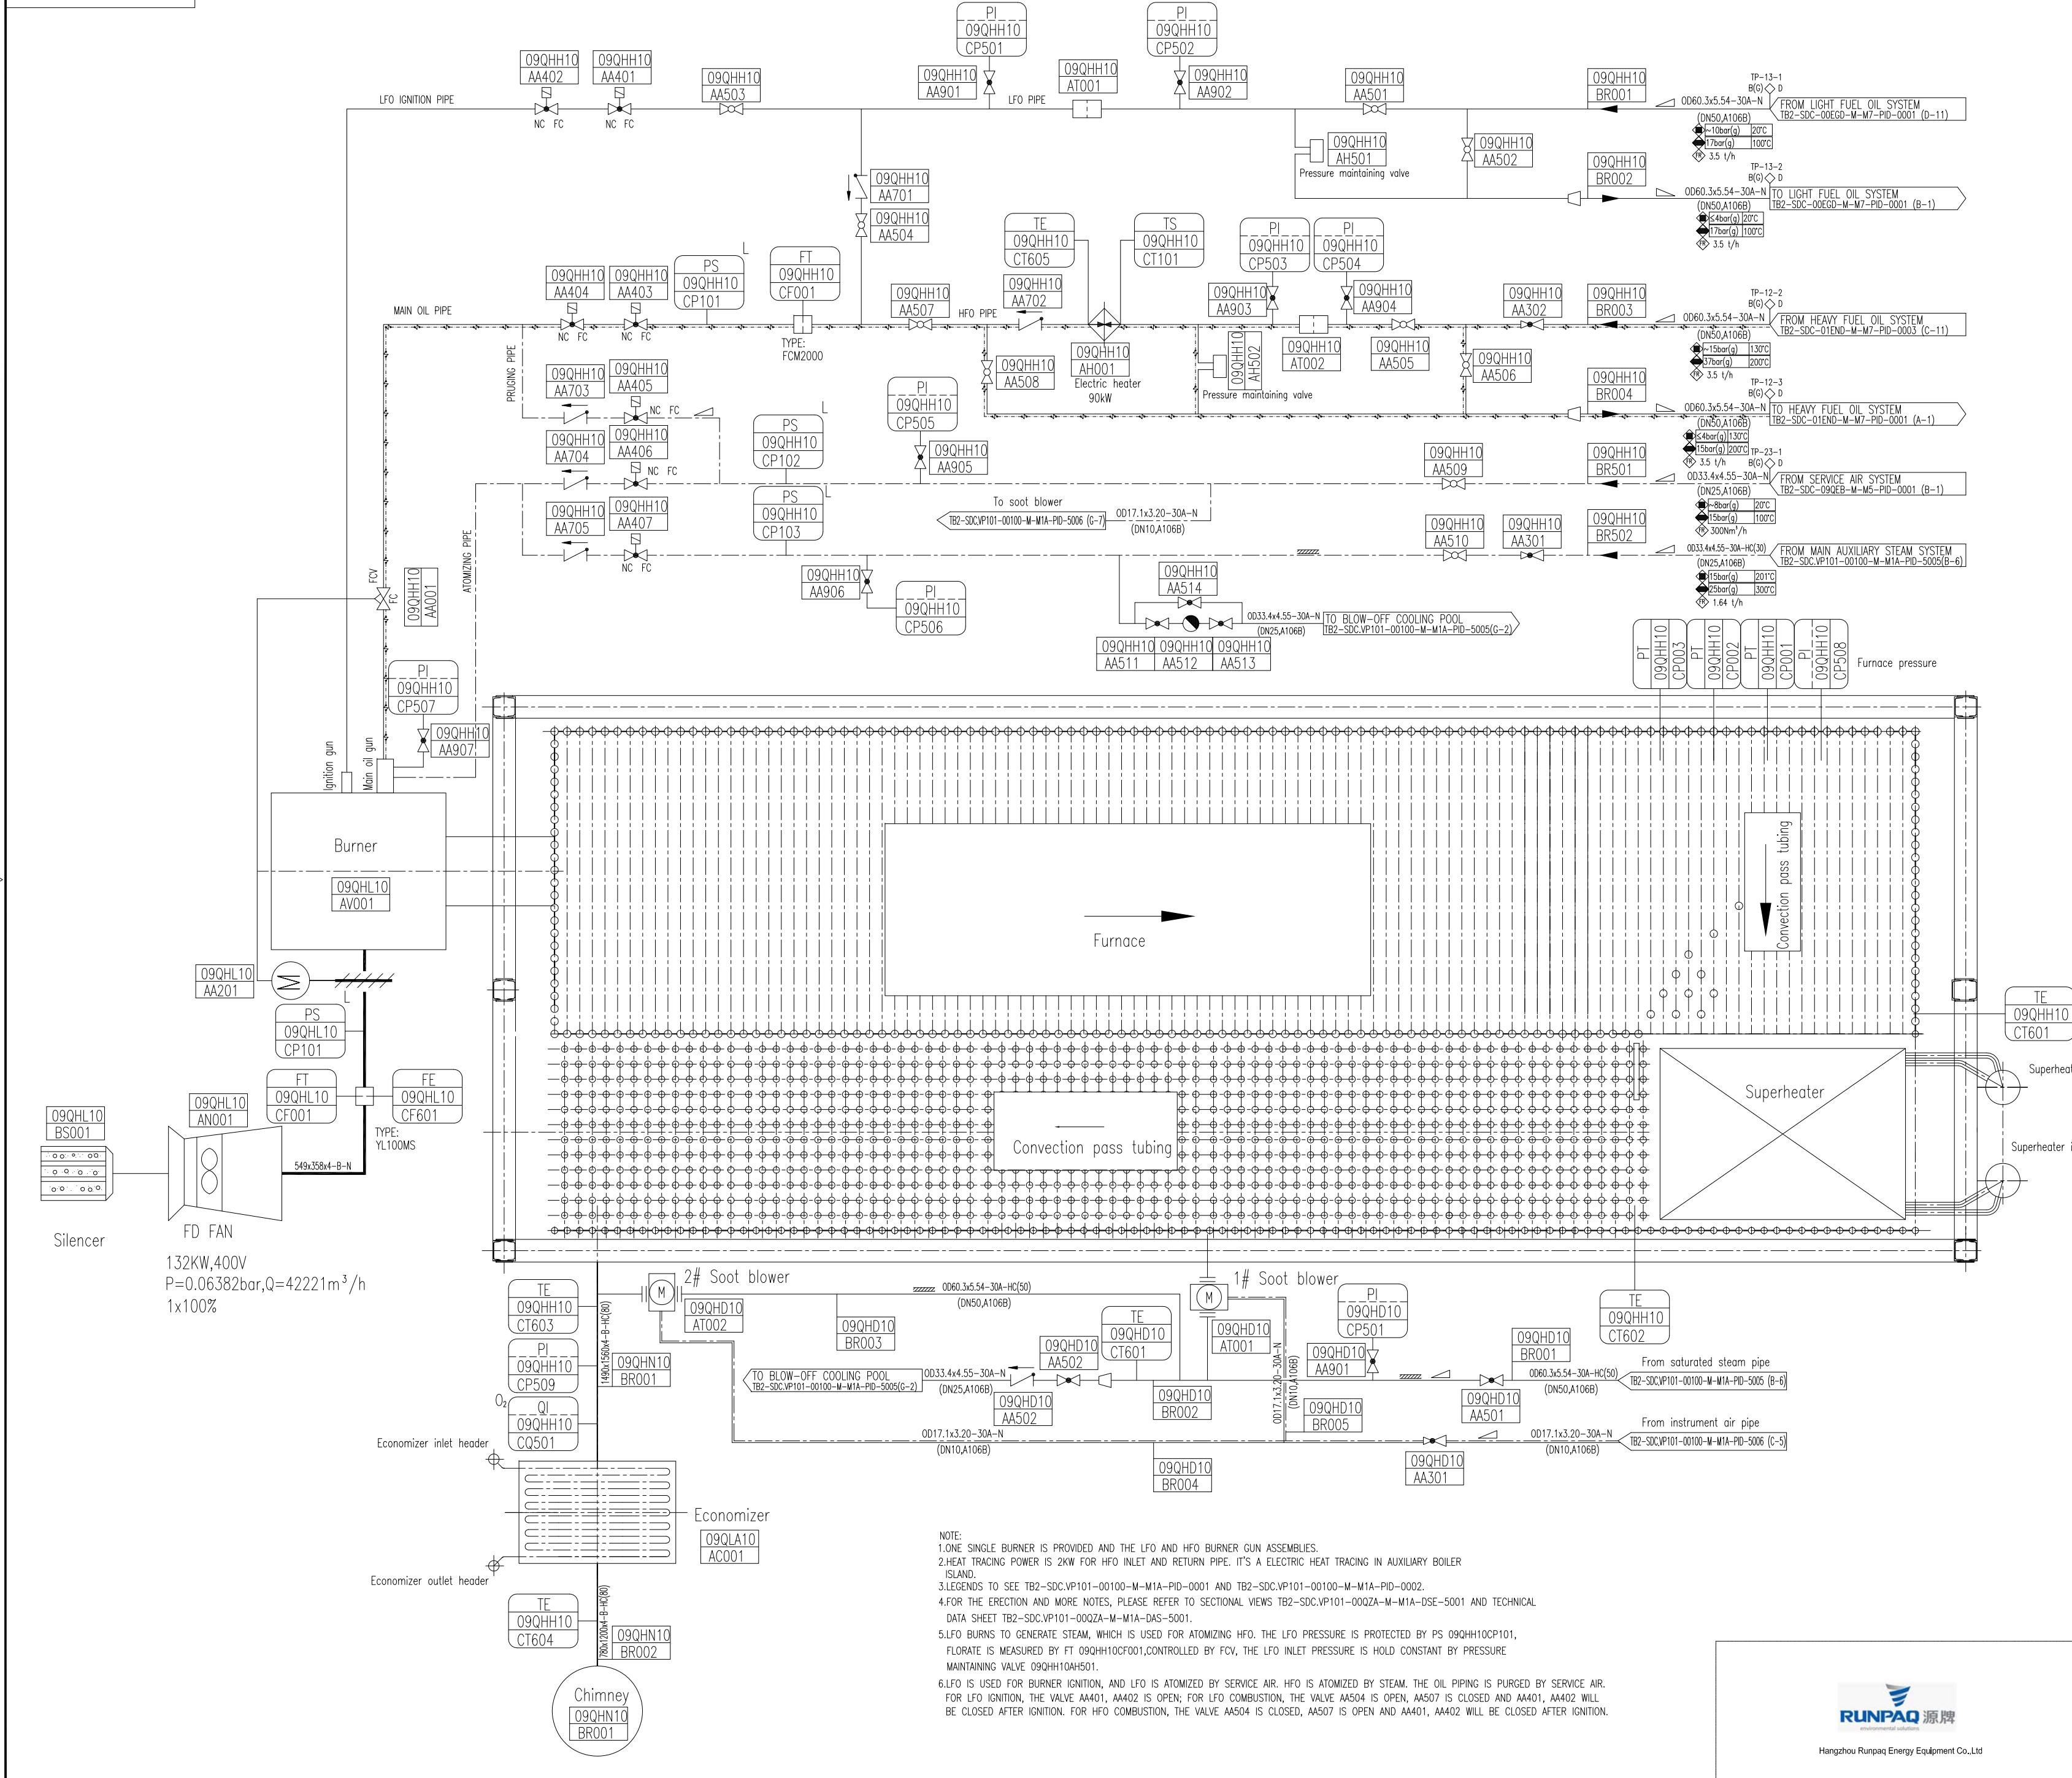

BURNER INSTRUMENTATION SHEET	
KKS CODE	NAME
09QHH10CP501	PRESSURE INDICATOR
09QHH10CP502	PRESSURE INDICATOR
09QHH10CP503	PRESSURE INDICATOR
09QHH10CP504	PRESSURE INDICATOR
09QHH10CP505	PRESSURE INDICATOR
09QHH10CP506	PRESSURE INDICATOR
09QHH10CP507	PRESSURE INDICATOR
09QHH10CP101	PRESSURE SWITCH
09QHH10CP102	PRESSURE SWITCH
09QHH10CP103	PRESSURE SWITCH
09QHL10CP101	PRESSURE SWITCH
09QHH10CT605	TEMPERATURE TRANSMITTER
09QHH10CT101	TEMPERATURE SWITCH
09QHH10CF001	FLOWMETER
09QHL10CF001	AIR FLOWMETER

Daelim Industrial Co., Ltd.	
job No.	110180
A	APPROVED
B	APPROVED WITH COMMENTS
C	RETURNED FOR CORRECTION
D	REJECTED
N	NOT APPLICABLE (REFERENCE ONLY)
SIGNED BY :	DATE :
DIC'S PERMISSION TO PROCEED OR REVIEW TAKEN ON VENDOR PRINTS SHALL NOT RELIEVE VENDOR FROM ITS RESPONSIBILITIES OR LIABILITIES UNDER THE PURCHASE ORDER.	

DOCUMENT SUBMISSION STATUS: FF	
NOTE:	
23 Jul.2015	FOR FINAL
21 Apr.2015	FOR FINAL
05 Jan.2015	FOR APPROVAL
01 Sep.2014	FOR APPROVAL
06 Jun.2014	FOR APPROVAL
REV	DATE DESCRIPTION DRWN CHKD REVD APRD

OWNER	VIETNAM OIL AND GAS GROUP (PJV)	OWNER'S CONSULTANT	FICHTNER GmbH & Co. KG
EPC CONTRACTOR	PT. PETROVIETNAM CONSTRUCTION JOINT STOCK CORPORATION (PVC)	EPC CONTRACTOR'S CONSULTANT	WorleyParsons
POWER ISLAND PACKAGE SUPPLIER	SOJITZ CORPORATION		DAELIM INDUSTRIAL CO., LTD.

PROJECT TITLE		THAI BINH2 THERMAL POWER PLANT 2 x 600MW	
DRAWING TITLE		AUXILIARY BOILER FUEL, AIR AND FLUE GAS P&ID	
BIP SUPPLIER	FUNCTION	NAME	SIGN
BAI COCK & WILCOX BEIJING CO., LTD.	DRWN	ZHANGKEWU	23 Jul.2015
	CHKD	LONGQIAOYUN	23 Jul.2015
	REVD	LIDONGTAO	23 Jul.2015
	APPD	WANGZHONGHONG	23 Jul.2015
DRAWING NO.	JOB NO.	SCALE	REVNO.
TB2-SDC.VP101-00100-M-MIA-PID-5006	110180	1/50	