


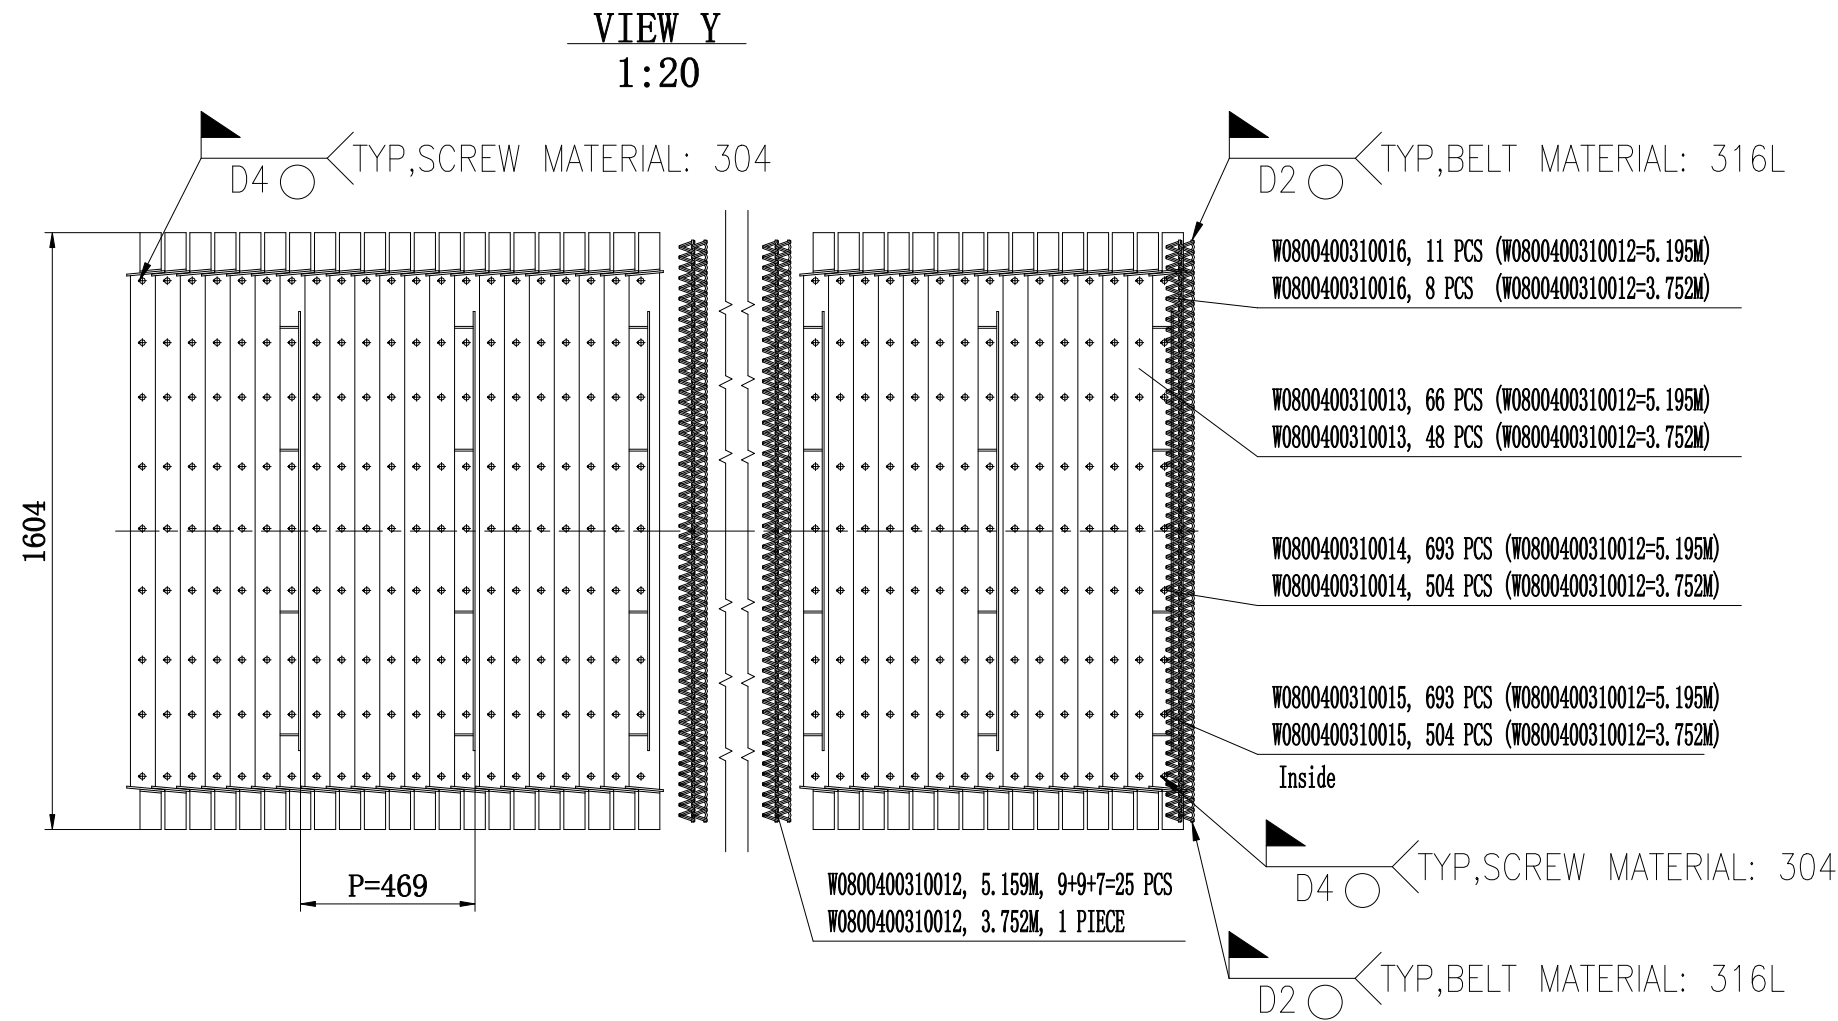
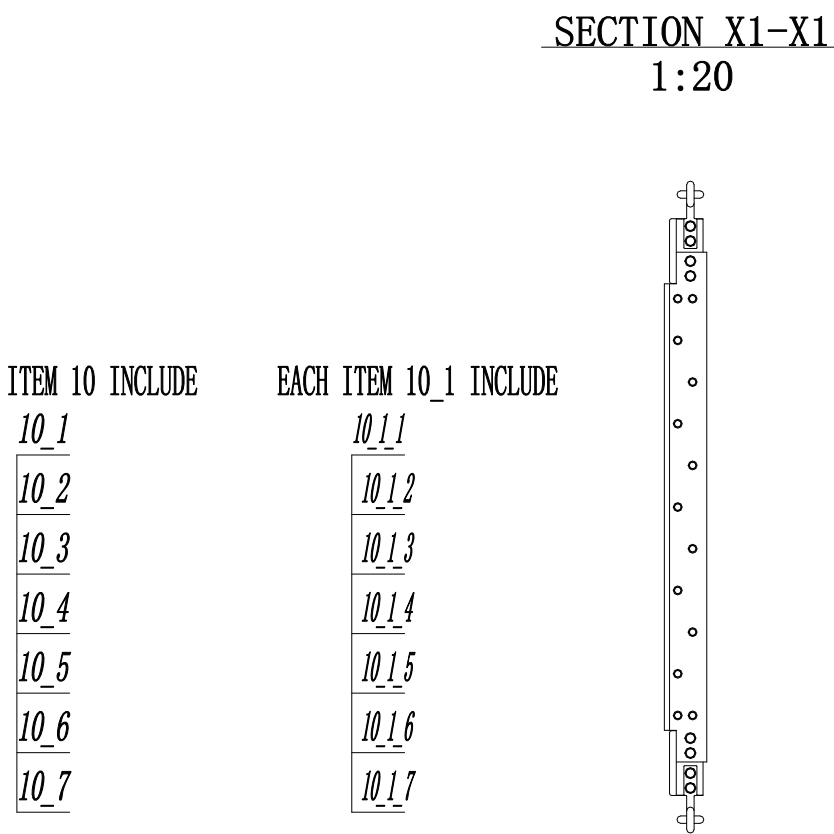


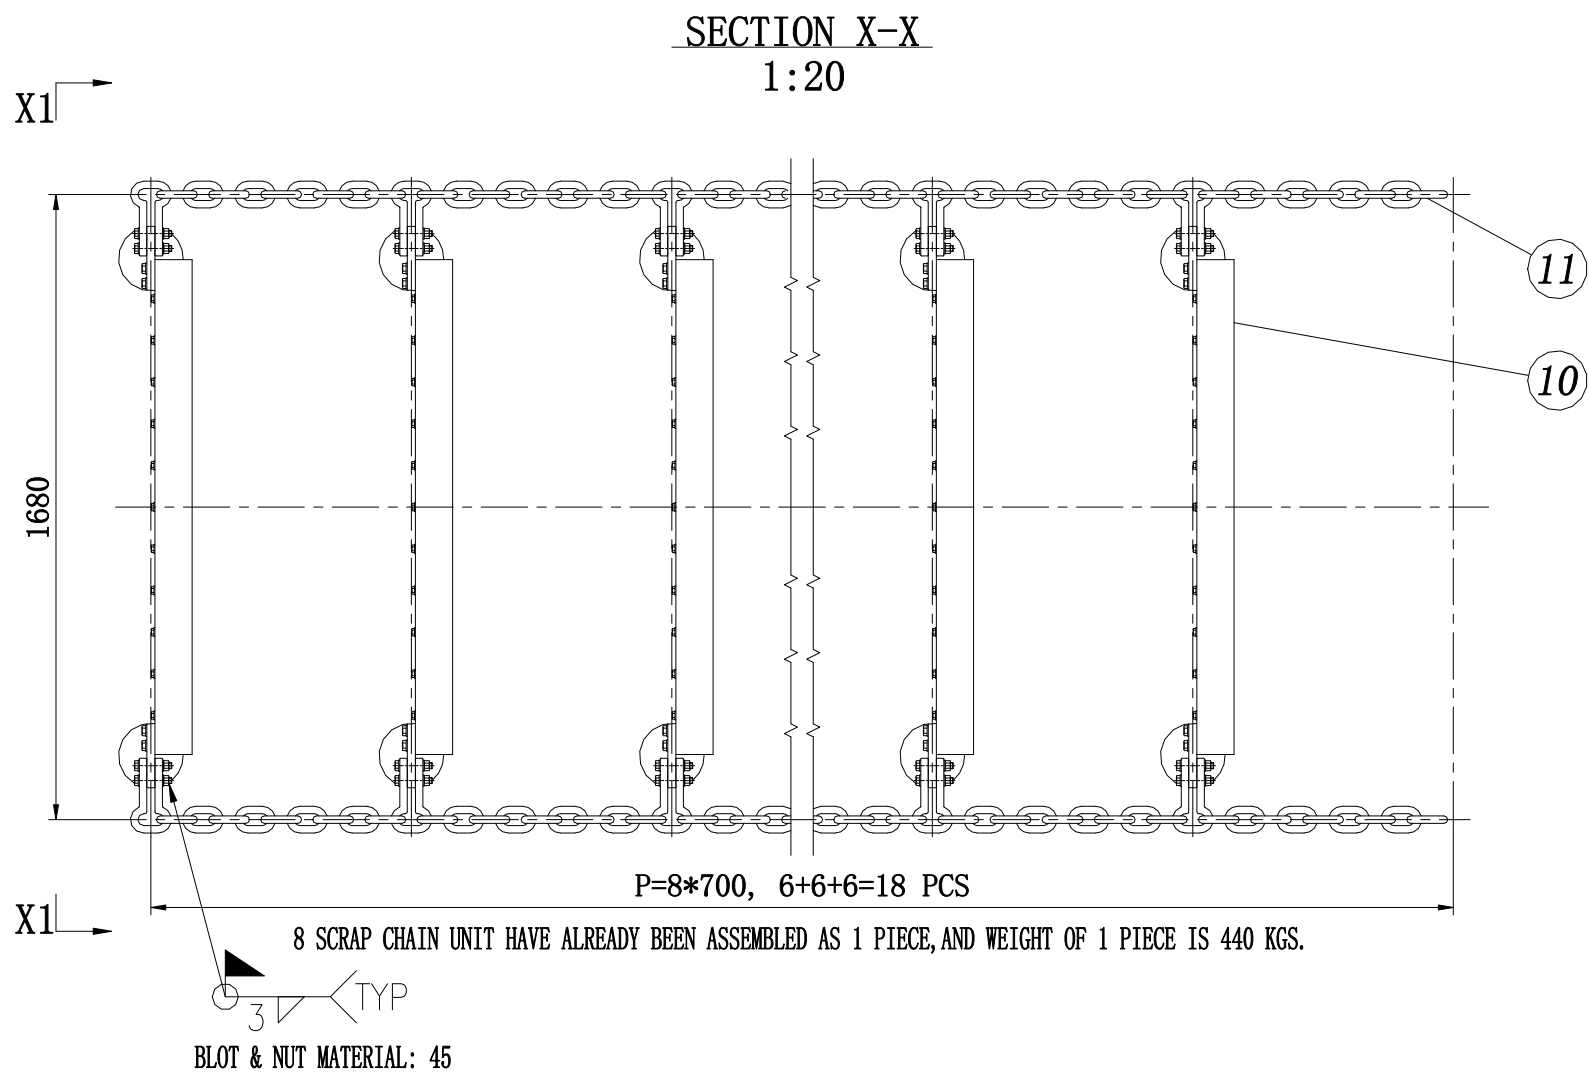


DETAIL 1
1:20

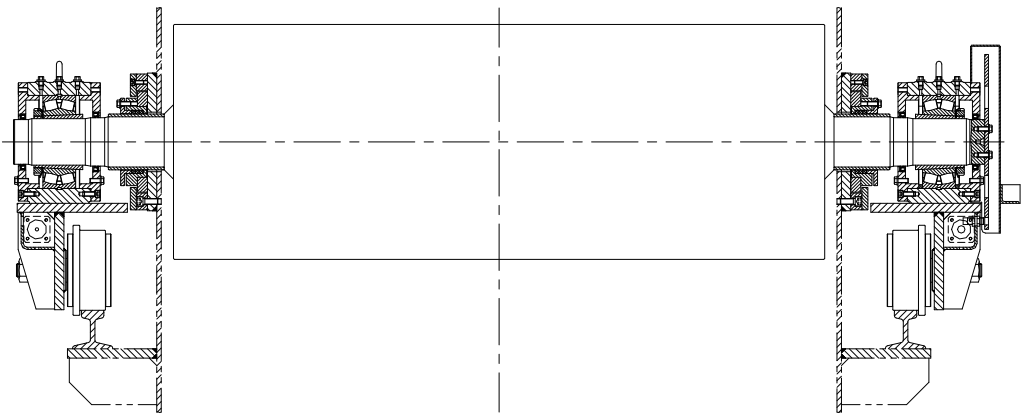


DETAIL 2
1:20

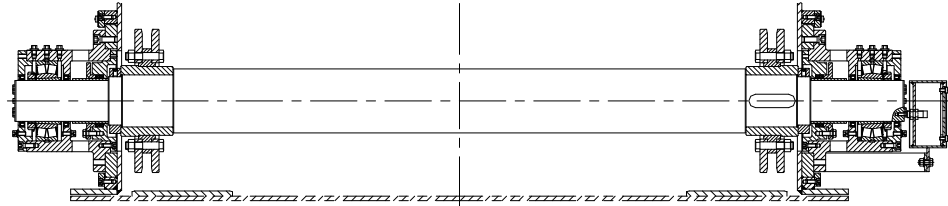


DETAIL 3
1:20

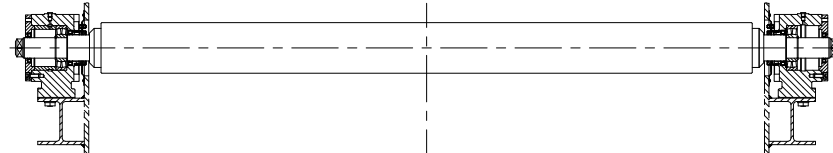


DETAIL 4
1:20

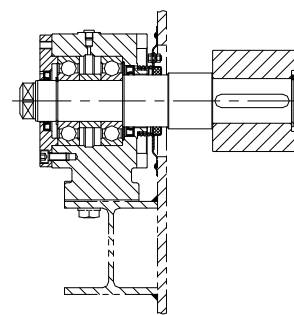


DETAIL 5
1:20

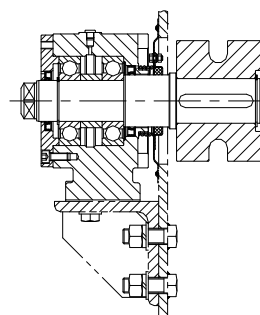


DETAIL 7
1:20

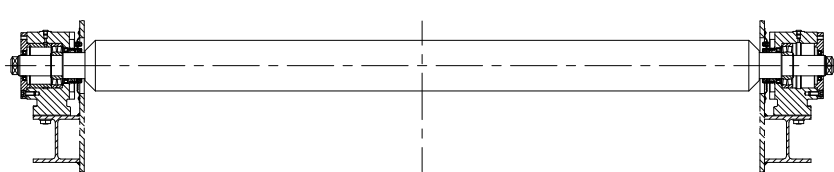


DETAIL 8
1:20

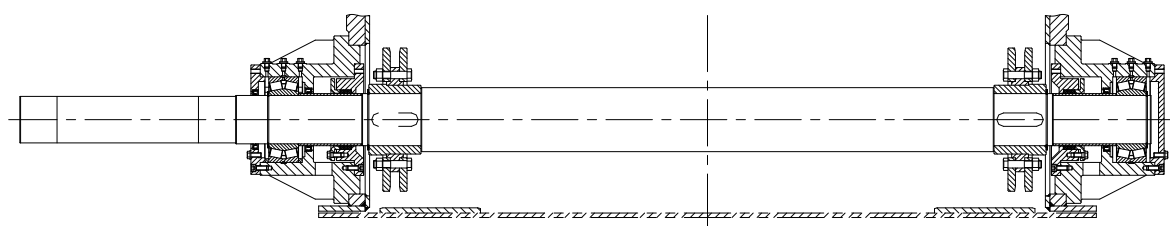

DETAIL 9
1:20

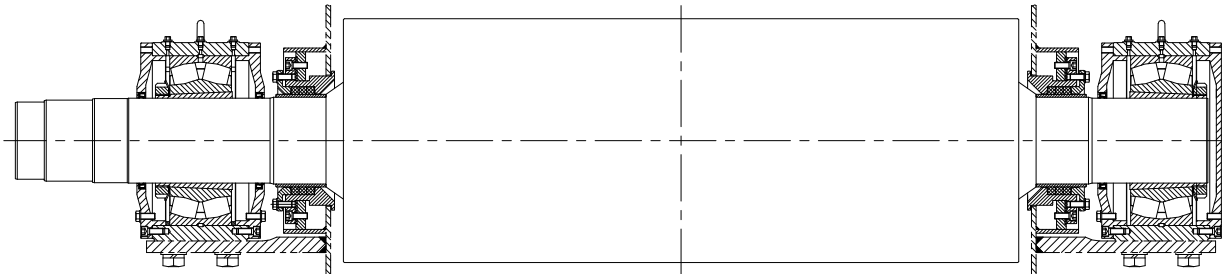

DETAIL 6
1:20

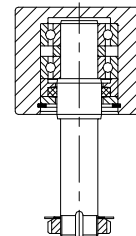

NOTES:

1. ALL DIMENSIONS AND ELEVATION ARE IN MILLIMETER (MM).
2. FINISHED GRADE ELEVATION EL. +0.00M = EL. +4.5M ABOVE MEAN SEA LEVEL.
3. ALL WELDS SHALL BE IN ACCORDING TO AWS D1.1.

WHEEL SYSTEM LIST (UNIT 1)						
⑨	B0203001800010	MAIN ROLLER OF CONVEYING BELT	1	PCS.	ASSEMBLY	2900 NOT IN THE DELIVERY LIST
⑧	B0203001800090	MAIN ROLLER OF SCRAP CHAIN	1	PCS.	ASSEMBLY	880 NOT IN THE DELIVERY LIST
⑦	B0203001800170	ARC CONVEYING UPPER PRESS WHEEL	12	PCS.	ASSEMBLY	3180 NOT IN THE DELIVERY LIST
⑥	B0203001800210	GUIDE WHEEL TYPE A	100	PCS.	ASSEMBLY	320 NOT IN THE DELIVERY LIST
⑤	B0203001800190	SCRAP CHAIN ROLLER	166	PCS.	ASSEMBLY	7968 NOT IN THE DELIVERY LIST
④	B0203001800180	RETURN ROLLER	248	PCS.	ASSEMBLY	11408 NOT IN THE DELIVERY LIST
③	B0203001800150	CONVEYING UPPER ROLLER	159	PCS.	ASSEMBLY	27189 NOT IN THE DELIVERY LIST
②	B0203001800100	TENSION DEVICE OF SCRAP CHAIN	1	PCS.	ASSEMBLY	1096 NOT IN THE DELIVERY LIST
①	B0203001800040	TENSION DEVICE OF CONVEYING BELT	1	PCS.	ASSEMBLY	3010 NOT IN THE DELIVERY LIST

ITEM	DRAWING TITLE ITEM CODE	ITEM NAME	QUAN.	UNIT	MATERIAL	WT KG	REMARK
					Daelim Industrial Co., Ltd.		
			job No.		110180		
			A – APPROVED				
			B – APPROVED WITH COMMENTS				
			C – RETURNED FOR CORRECTION				
			D – REJECTED				
			N – NOT APPLICABLE (REFERENCE ONLY)				
			SIGNED BY :		DATE :		
DIC'S PERMISSION TO PROCEED OR REVIEW TAKEN ON VENDOR PRINTS SHALL NOT RELIEVE VENDOR FROM ITS RESPONSIBILITIES OR LIABILITIES UNDER THE PURCHASE ORDER.							

DOCUMENT SUBMISSION STATUS: FF
NOTE:

△	18 Aug.2016	FOR FINAL	LIU ZHENGE	DOU HONGJUN	YANG ZUNHAO	MA YI
REV	DATE	DESCRIPTION	DRWN	CHKD	REVD	APRD

OWNER		OWNER'S CONSULTANT	
 VIETNAM OIL AND GAS GROUP (PVN)		 FICHTNER PV POWER PCC	
EPC CONTRACTOR		EPC CONTRACTOR'S CONSULTANT	
 PETROVIETNAM CONSTRUCTION JOINT STOCK CORPORATION (PVC)		 WORLEYPARSONS	
POWER ISLAND PACKAGE SUPPLIER			

 SOJITZ CORPORATION		 DAELIM INDUSTRIAL CO., LTD.	
------------------------	--	---------------------------------	--

PROJECT TITLE THAI BINH2 THERMAL POWER PLANT 2 x 600MW

DRAWING TITLE ASSEMBLY DRAWING OF DRY-TYPE SLAG CONVEYOR
SCRAP CHAIN,STEEL BELT,WHEEL SYSTEM DETAILS

BIP SUPPLIER	 BARCOCK & WILCOX BEIJING CO., LTD.	FUNCTION	NAME	SIGN	DATE
		DRWN	LIU ZHENGE		18 Aug.2016
BIP SUB-SUPPLIER	 CEEC 广东省电力设计研究院 CHINA ELECTRIC POWER DESIGN INSTITUTE	CHKD	DOU HONGJUN		18 Aug.2016
		REVD	YANG ZUNHAO		18 Aug.2016
		APPD	MA YI		18 Aug.2016
DRAWING NO. TB2-SDC.VP101-00100-M-W12-DSU-0221		JOB NO. 110180		SCALE 1/200	REV.NO. 